


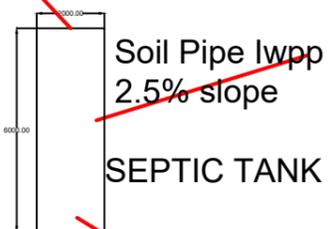






Soil Pipe to soak pit




Soil Pipe rinpung  
2.5 % slope

Drain

Cross drain with grating

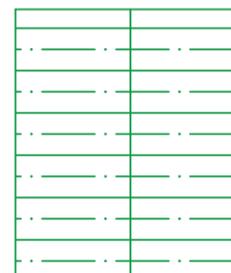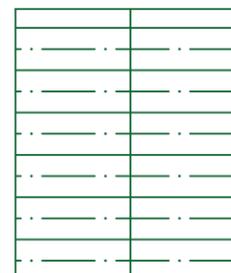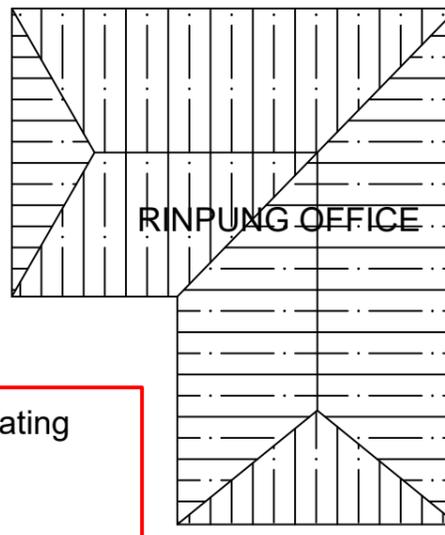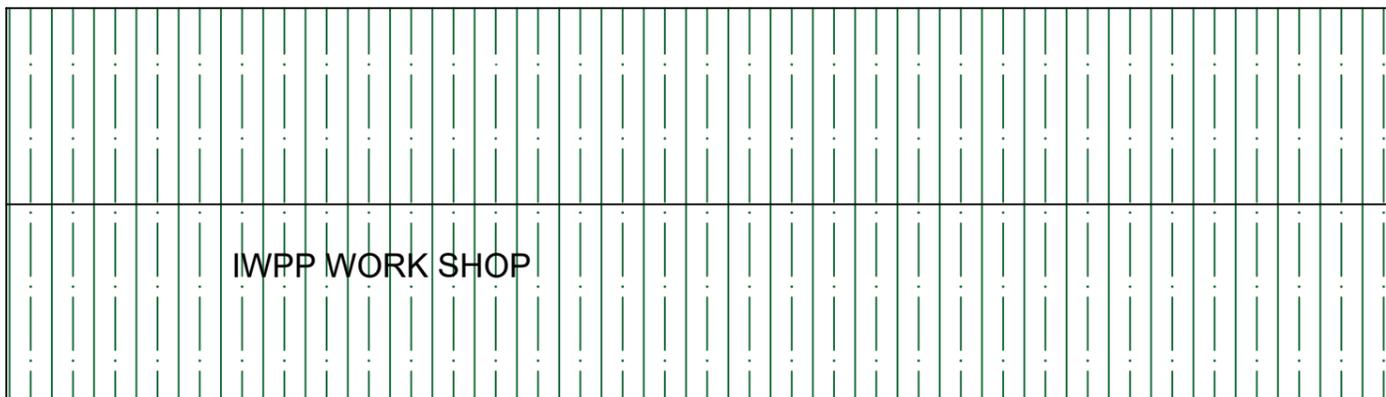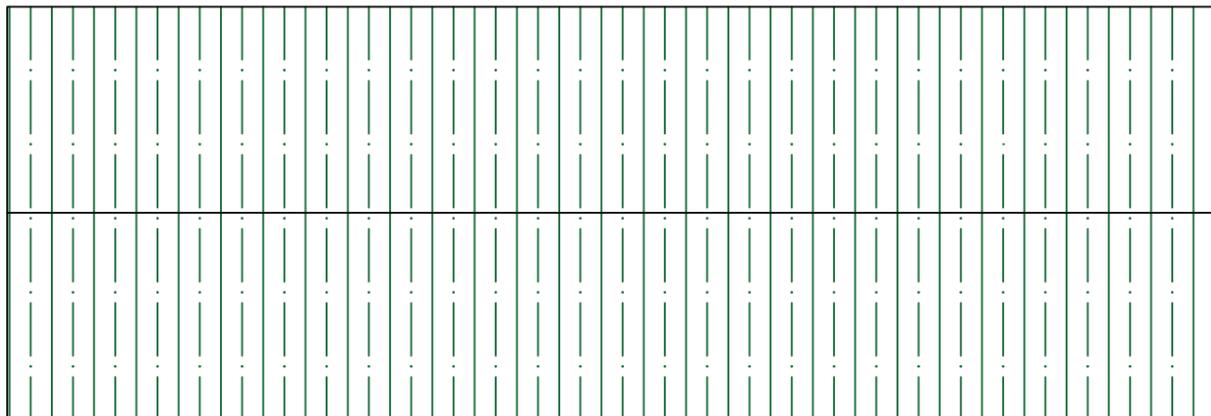


PROJECT	LOCATION	DRAWING		ENGINEER
Construction and maintenance of toilets	Lanjophakha, Thimphu	Plan of soil pipe layout	T-01	BISHAL SUBBA & SANGAY LEYTHRO NRDCL, HO
<p>Note:</p> <ul style="list-style-type: none"> <li>• Drawings are to be read only and not to be measured.</li> <li>• All dimensions are in millimeters unless stated otherwise.</li> </ul>		When in doubt, please ask, do not assume.	Scale: NTS	

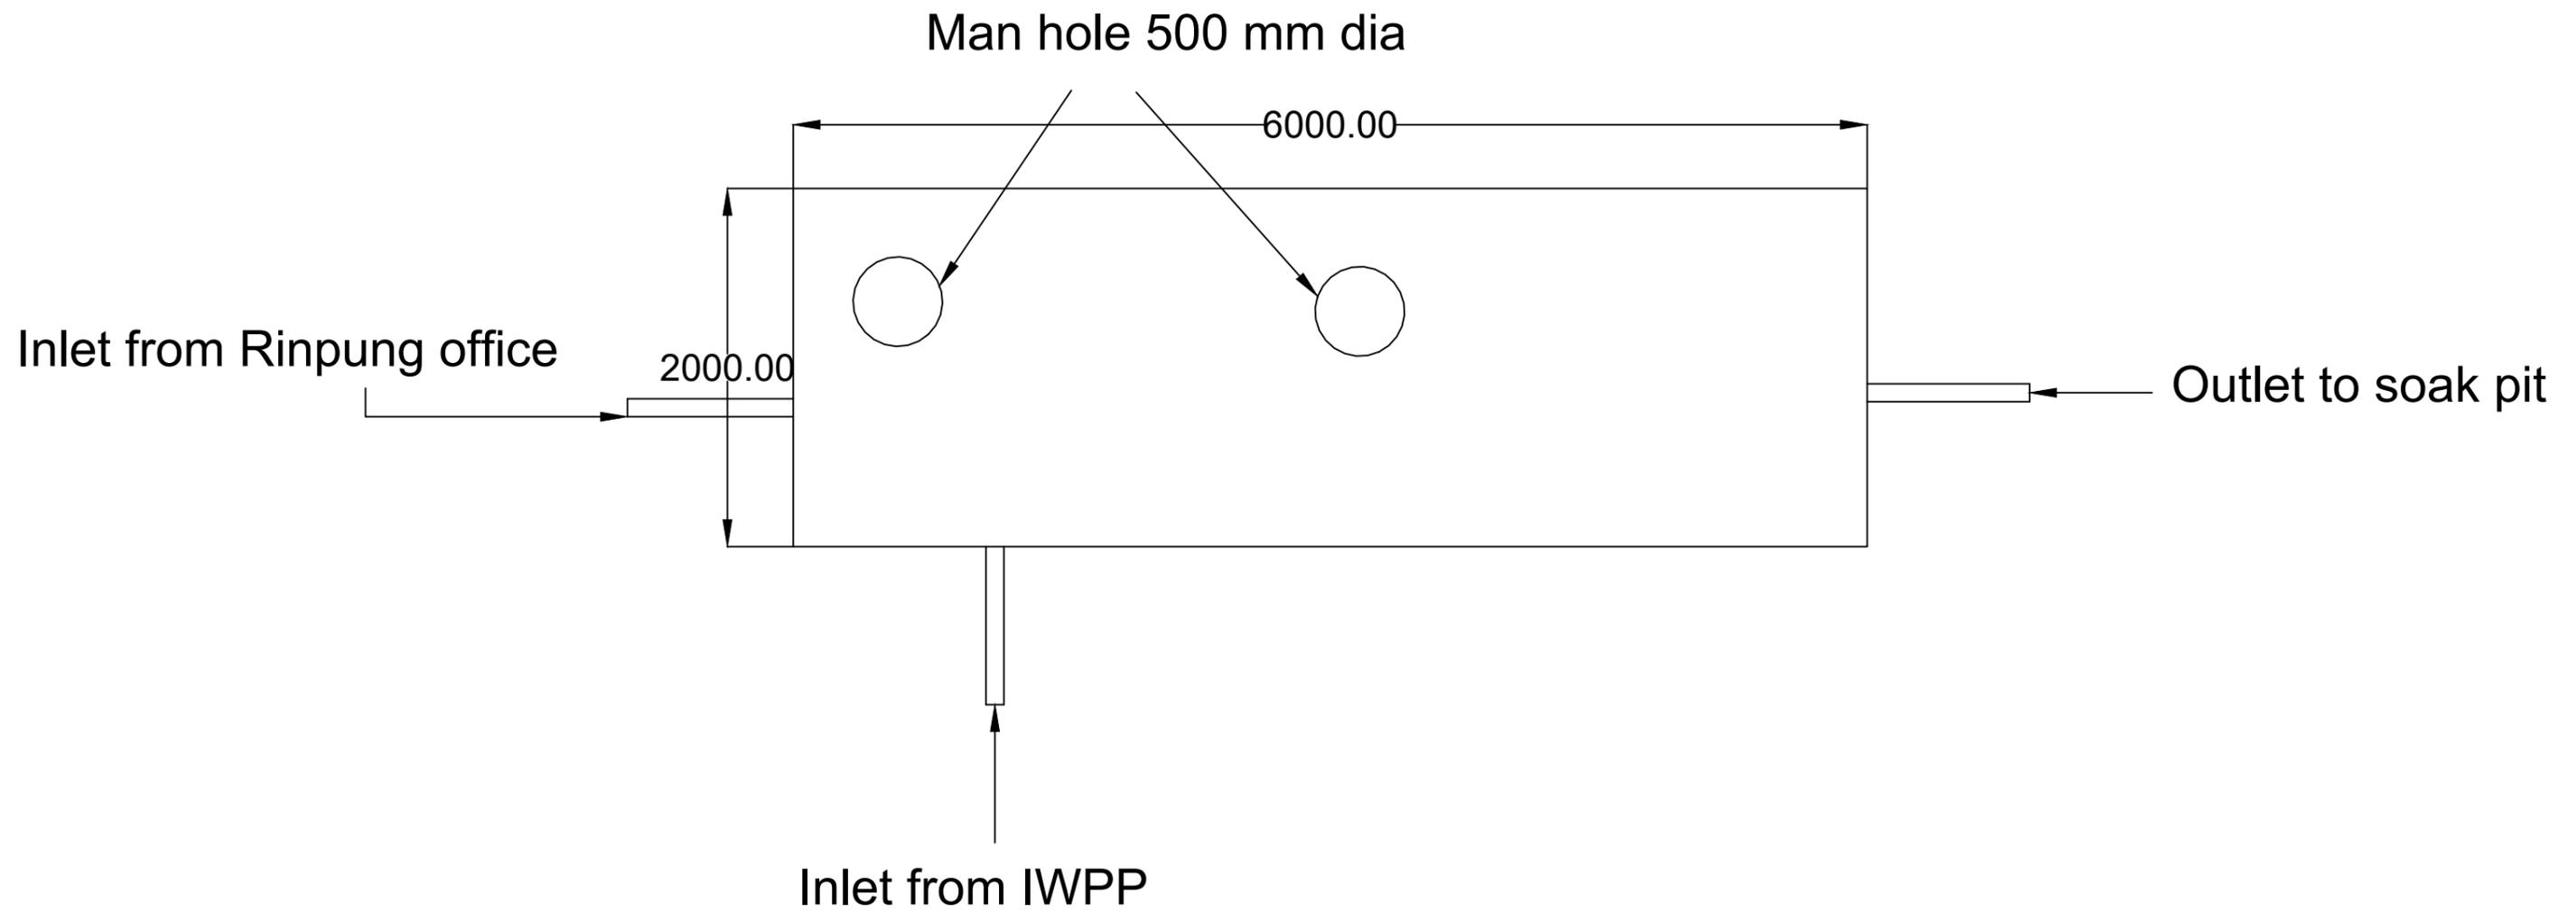


PROJECT	LOCATION	DRAWING		ENGINEEER
Construction and maintenance of toilets	Lanjophakha, Thimphu	Septic tank plan	T-02	 BISHAL SUBBA & SANGAY LEYTHRO NRDCL, HO
	Note: • Drawings are to be read only and not to be measured. • All dimensions are in millimeters unless stated otherwise.	<i>When in doubt, please ask, do not assume.</i>	Scale: NTS	

Inlet from Rinpung office

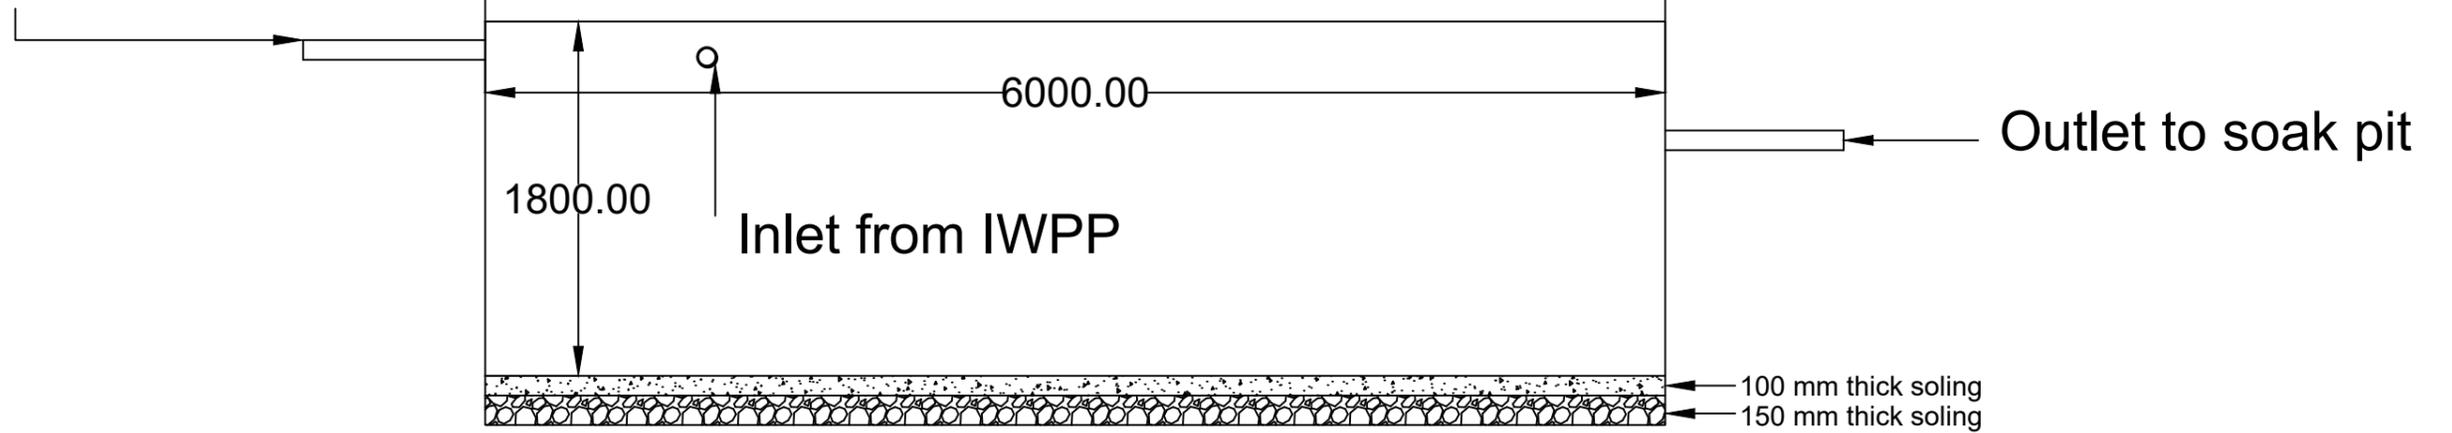


PROJECT	LOCATION	DRAWING			ENGINEER
Construction and maintenance of toilets	Lanjophakha, Thimphu	Septic tank elevation	T-03		BISHAL SUBBA & SANGAY LEYTHRO NRDCL, HO
<p><b>Note:</b></p> <ul style="list-style-type: none"> <li>• Drawings are to be read only and not to be measured.</li> <li>• All dimensions are in millimeters unless stated otherwise.</li> </ul>		<p><i>When in doubt, please ask, do not assume.</i></p>	<p>Scale: NTS</p>		

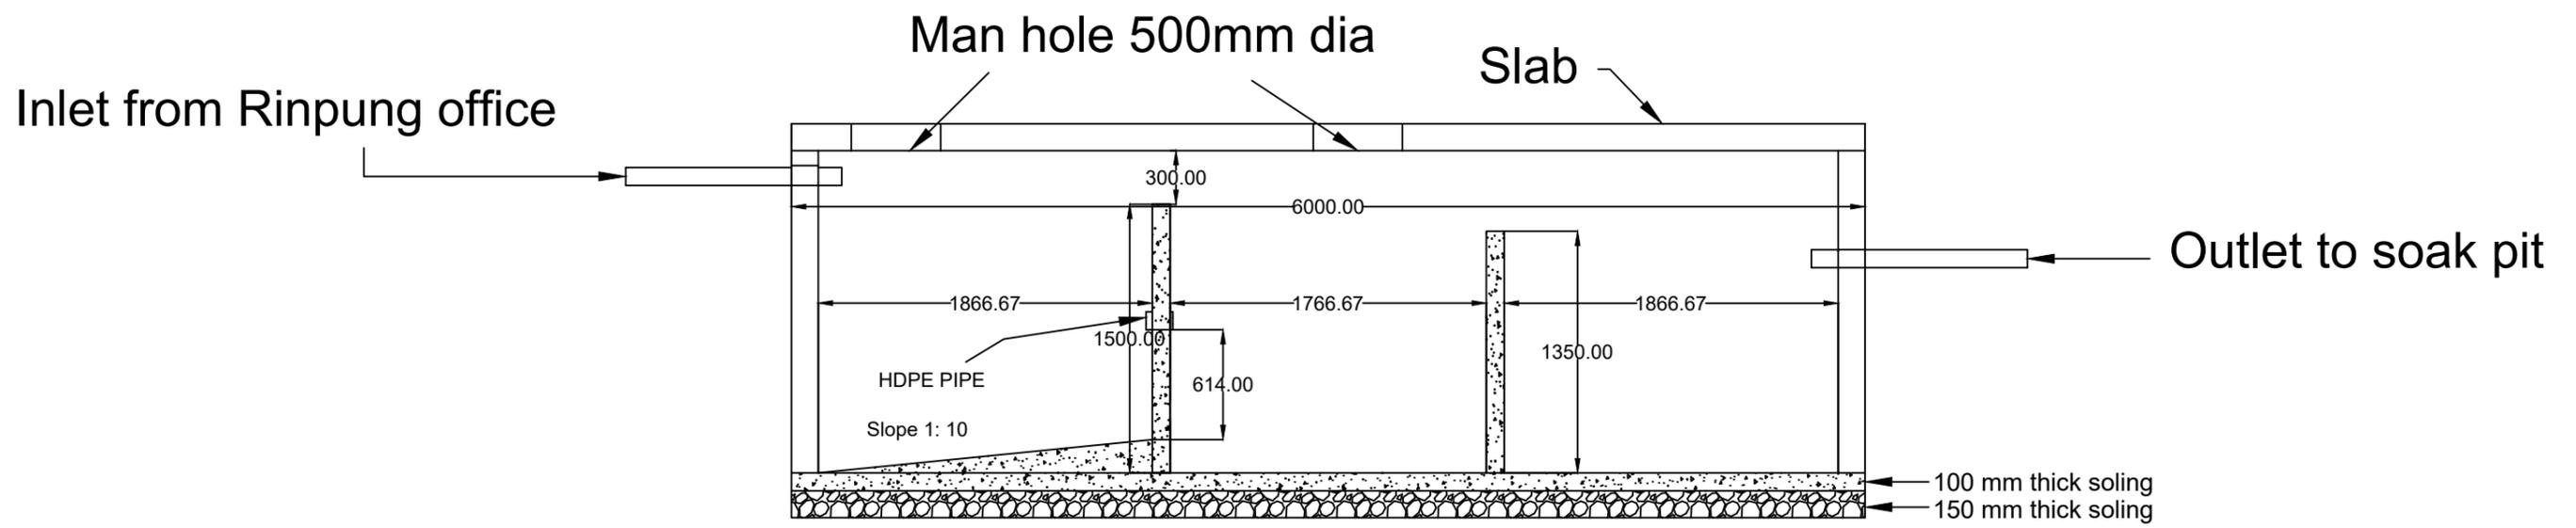


PROJECT	LOCATION	DRAWING		ENGINEEER
Construction and maintenance of toilets	Lanjophakha, Thimphu	Septic tank section	T-04	BISHAL SUBBA & SANGAY LEYTHRO NRDCL, HO
	<small>Note:</small> <ul style="list-style-type: none"> <li>• Drawings are to be read only and not to be measured.</li> <li>• All dimensions are in millimeters unless stated otherwise.</li> </ul>	Scale: NTS		

*When in doubt, please ask, do not assume.*

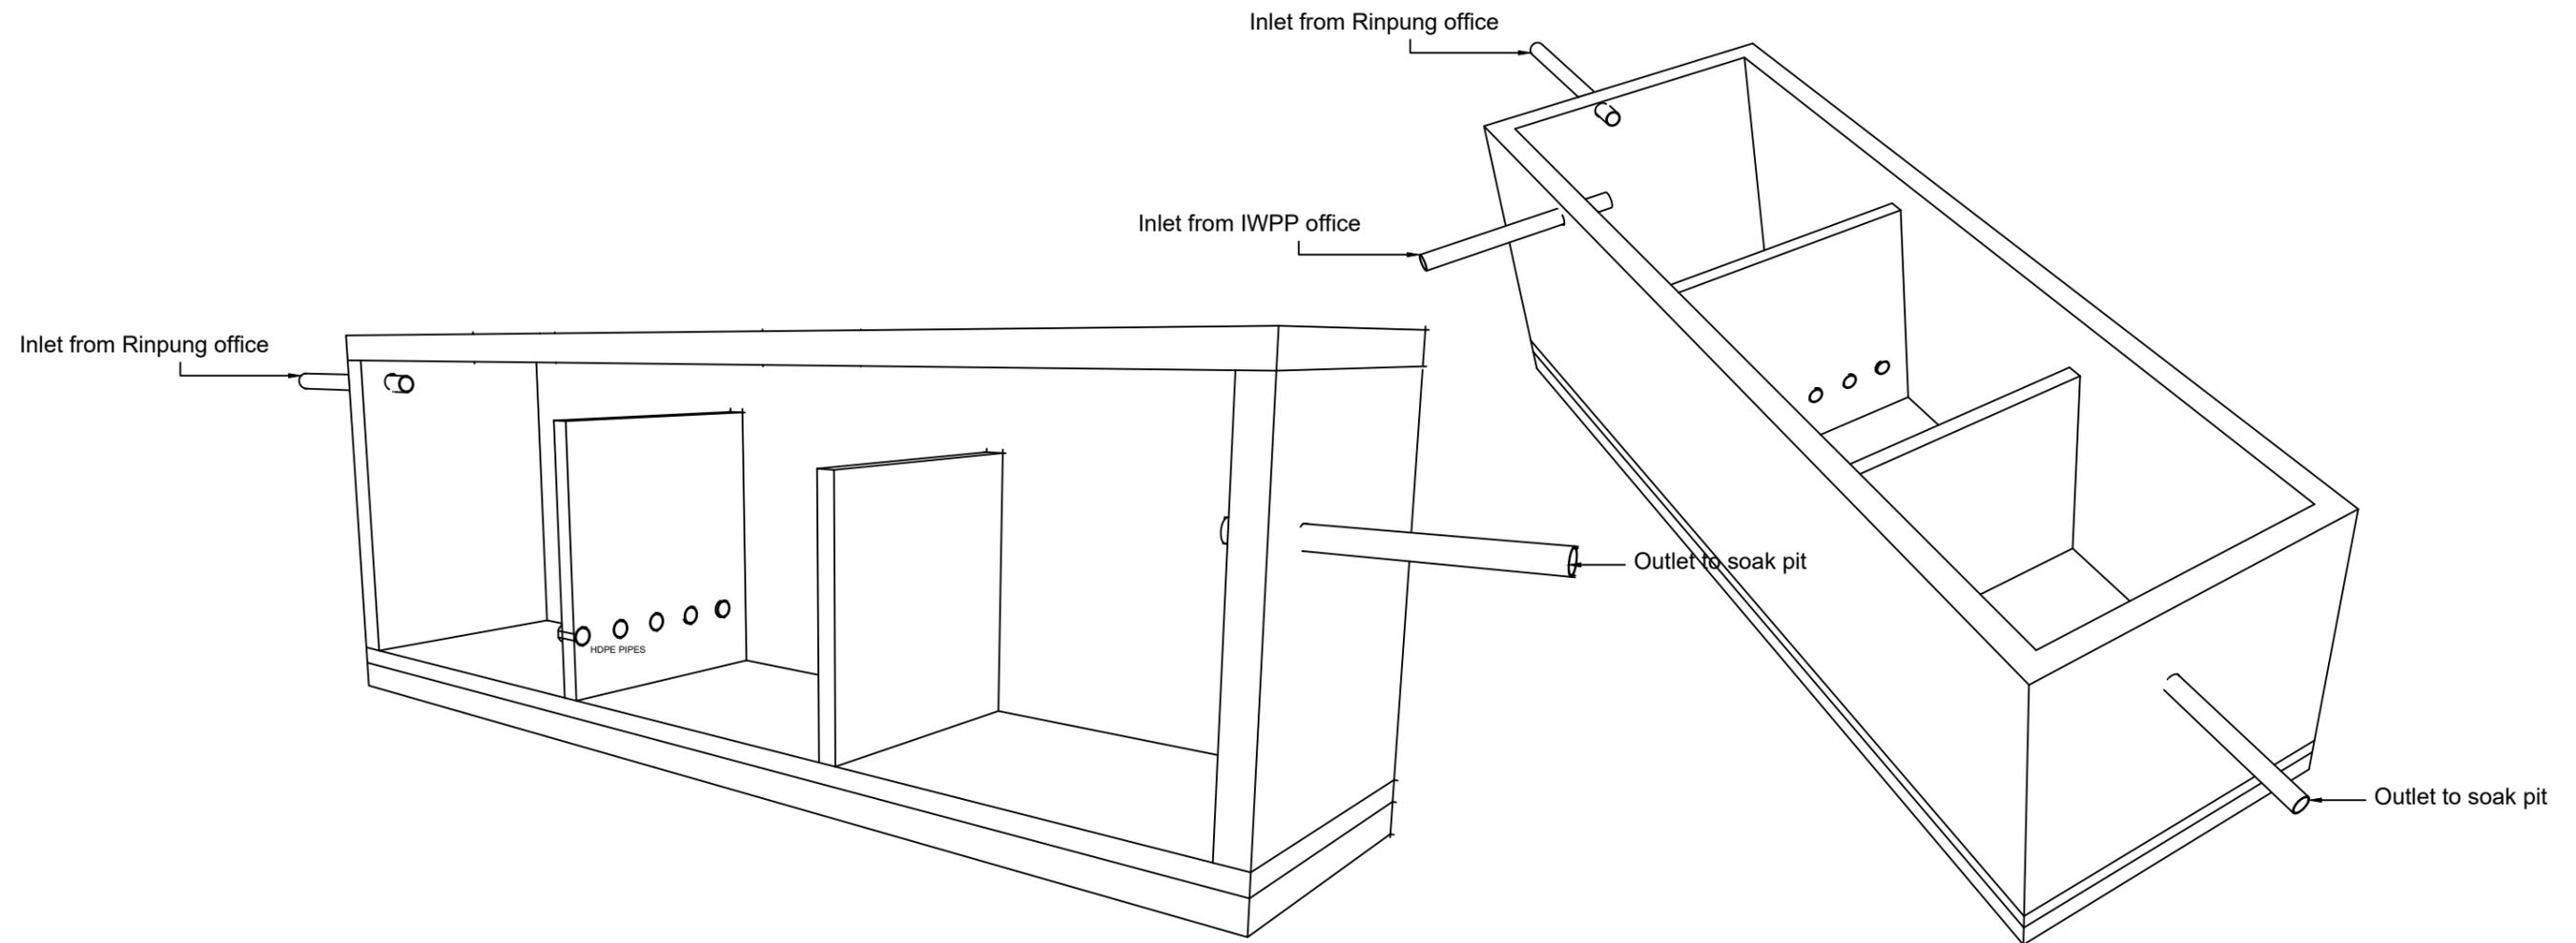

PROJECT	LOCATION	DRAWING		ENGINEER
Construction and maintenance of toilets	Lanjophakha, Thimphu	Septic tank isometric view	T-05	BISHAL SUBBA & SANGAY LEYTHRO NRDCL, HO
	Note: • Drawings are to be read only and not to be measured. • All dimensions are in millimeters unless stated otherwise.	<i>When in doubt, please ask, do not assume.</i>	Scale: NTS	

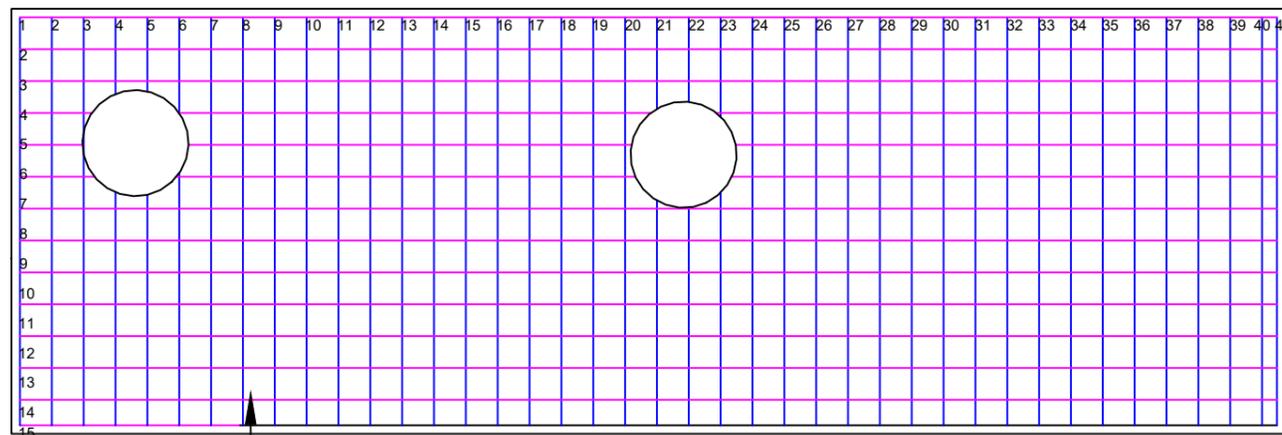


10T @ 150 mm c/c both ways


10T @ 150 mm c/c both ways




10T @ 150 mm c/c both ways

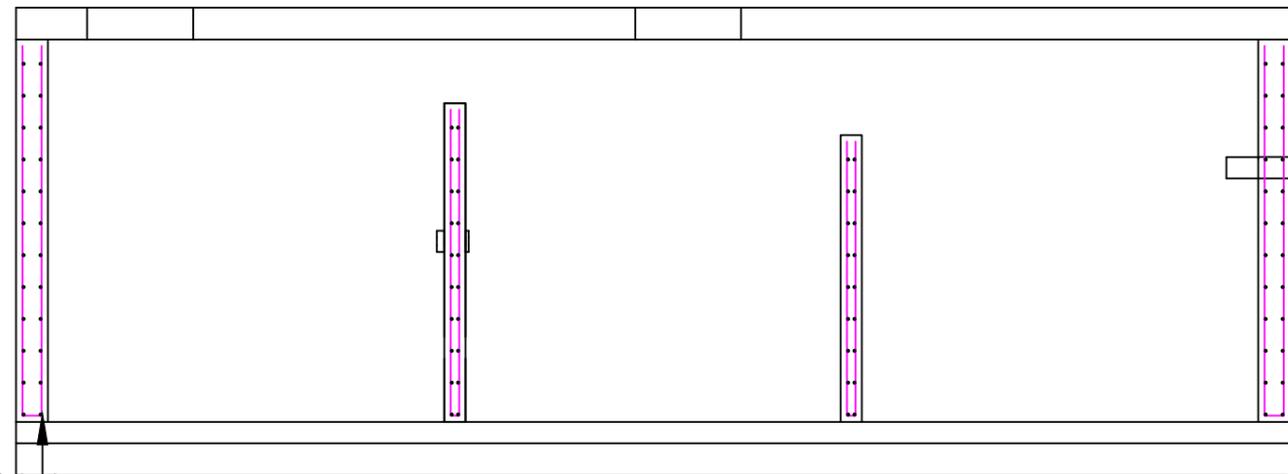

PROJECT	LOCATION		DRAWING		ENGINEEER
Construction and maintenance of toilets	Lanjophakha, Thimphu		Reinforcement details	T-06	
	<p>Note:</p> <ul style="list-style-type: none"> <li>• Drawings are to be read only and not to be measured.</li> <li>• All dimensions are in millimeters unless stated otherwise.</li> </ul>	<i>When in doubt, please ask, do not assume.</i>	Scale: NTS	BISHAL SUBBA & SANGAY LEYTHRO NRDCL, HO	

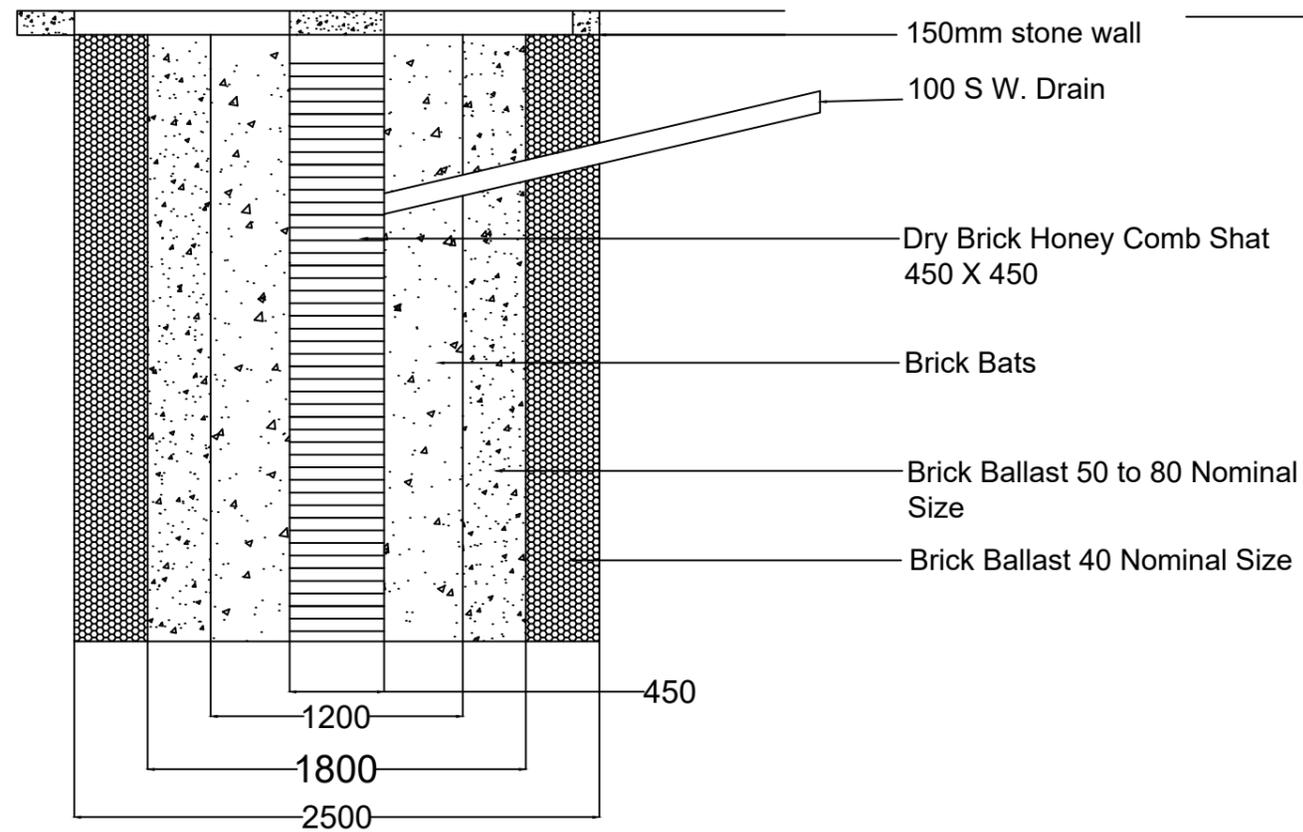

SECTION A-B

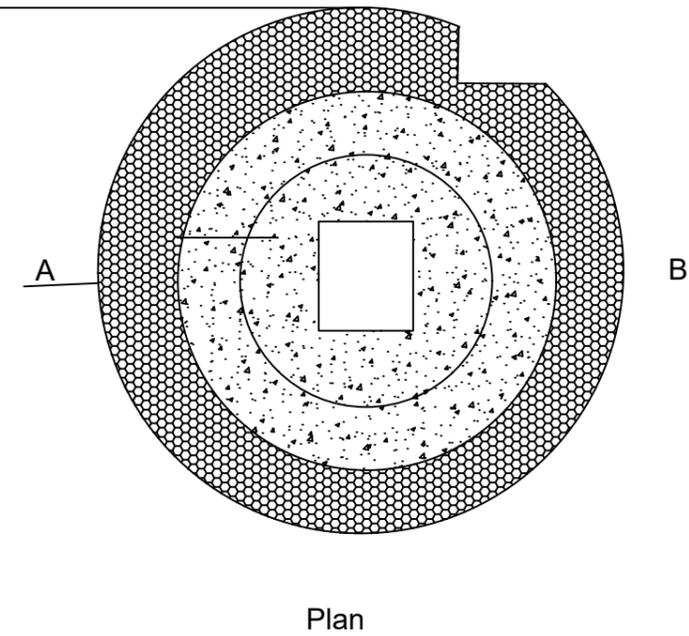

PROJECT :	Construction of two unit toilet at Tsapay depot	 <b>NRDCL</b> A dhi Company	NATURAL RESOURCES DEV.CROP.LTD ROYAL GOVERNMENT OF BHUTAN	NOTES: DIMENSION ARE IN MM UNLESS SPECIFIED. ALL DIMENSION MEASURES UNFINISHED SURFACE UNLESS SPECIFIED ALL DIMENSION ARE TO BE READ AND NOT TO BE SCALED OFF ANY DISCREPANCY IN THE DRAWING TO BE BROUGHT TO THE NOTICE OF THE PERSON INCHARGE	DESIGNED AND DRAWN BY:	VERIFIED BY:	APPROVED BY:	SCALE:	DRAWING NO:
TITLE :	Plan and section for soak pit				Sangay Leythro	Bishal Subba		NTS	05